



External

Outdoor Unit 1

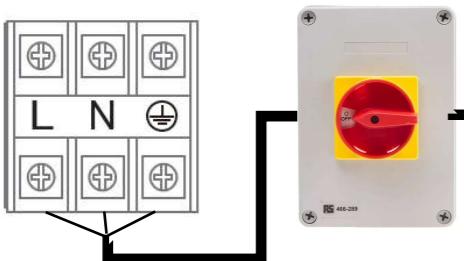


Outdoor Unit 2

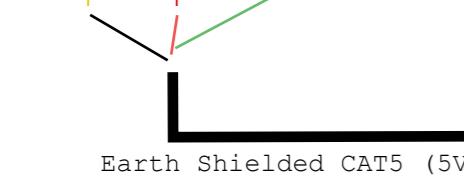


Hot Press / Plant Room

Main Fuse Box

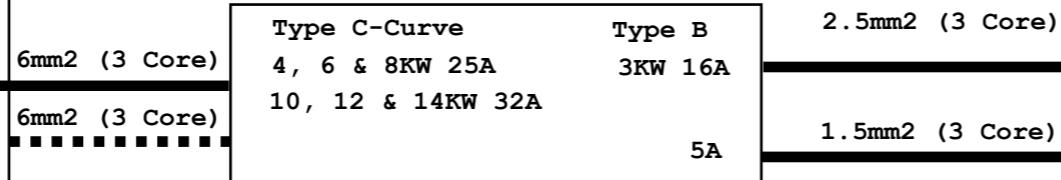

HP290 Control Box

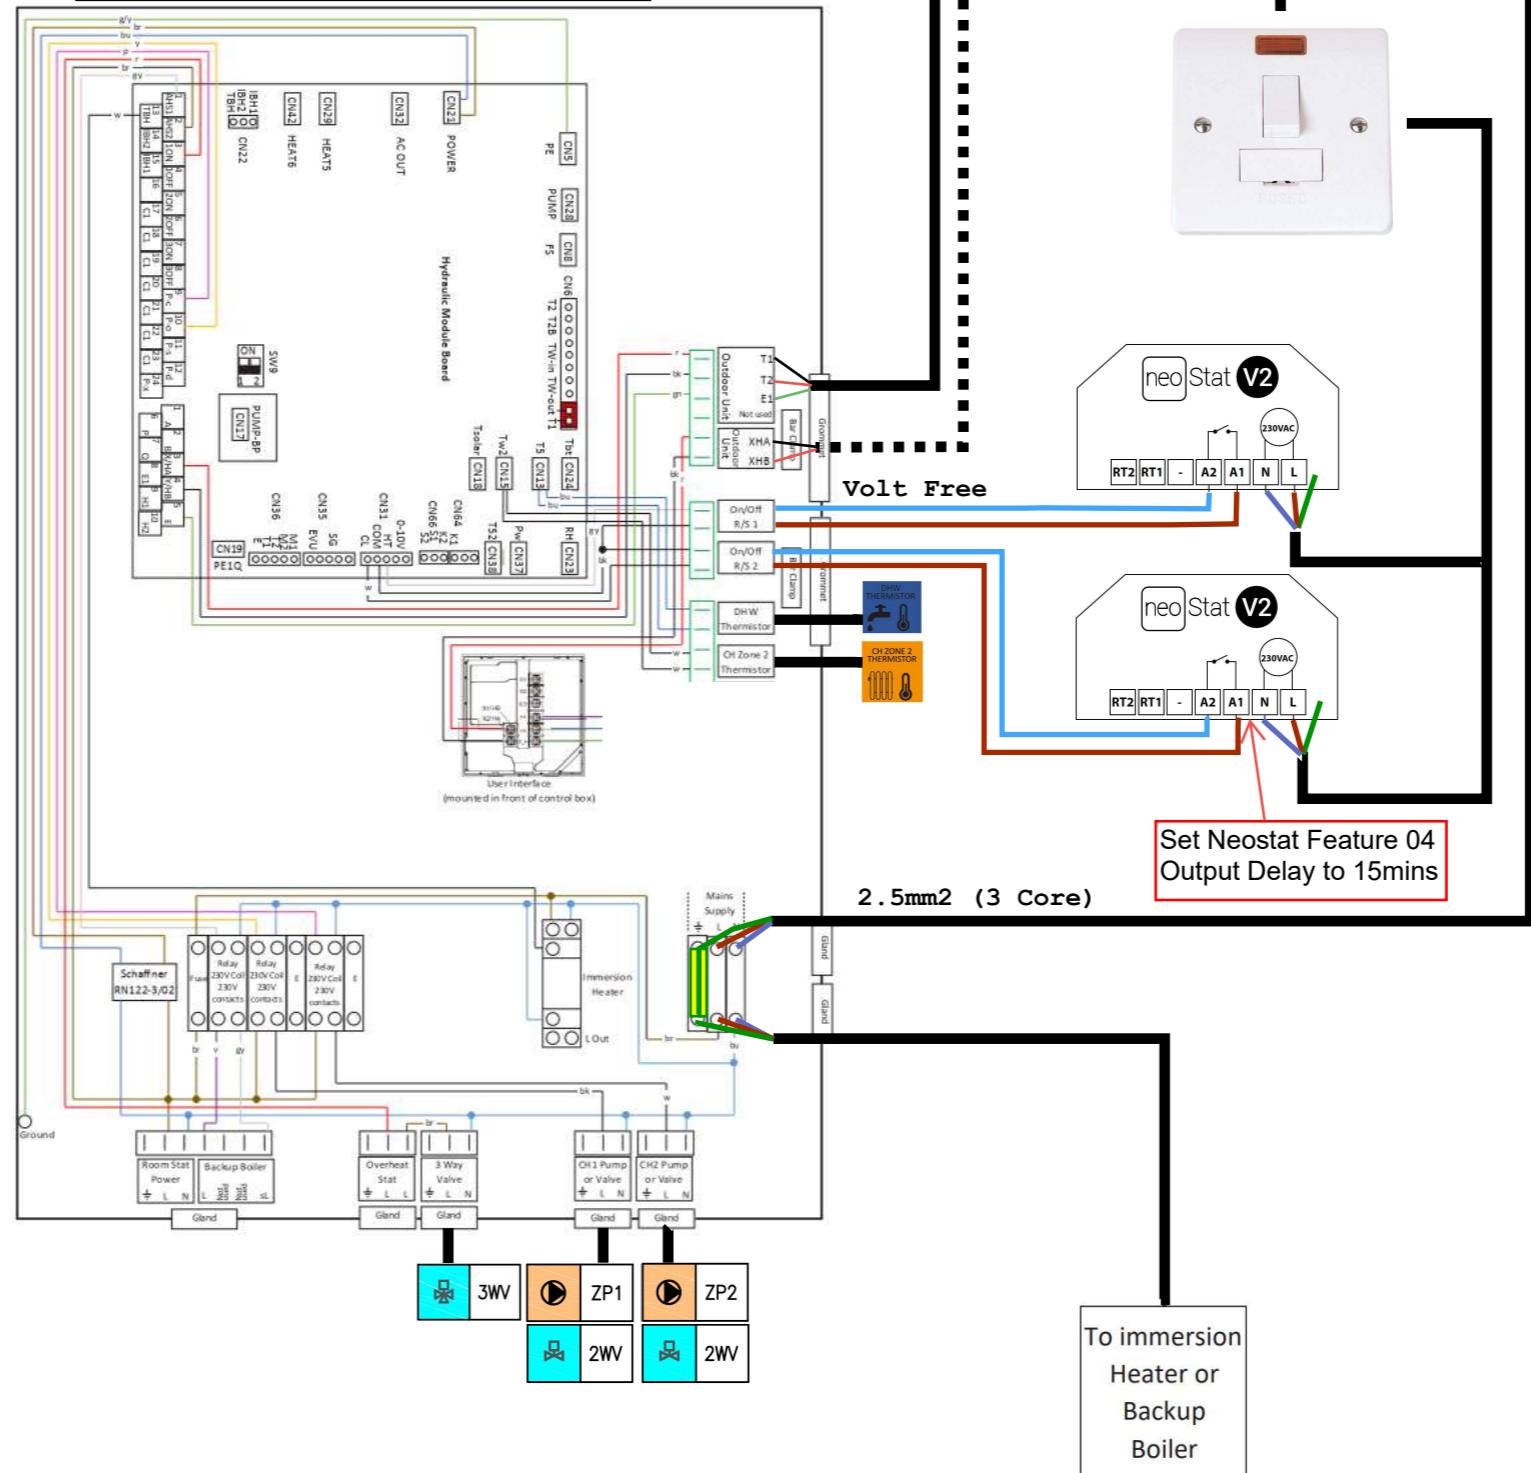

Notes

This diagram is intended for use in Ireland as an overview of connection terminals and cable sizes for use on site.

Please refer to the manufacturers Installation Guide for full electrical details and guidance.

All connections should be verified for polarity by a qualified electrician.

Full Installation Guide



Training Videos



IDEAL ENERGY
The Complete Solution

Ideal Energy Distribution Ltd.

Drawn By Odhran Casey

Date 20/01/26

Drawing HP290 Wiring